


PLOT DATE: 10/19/2026

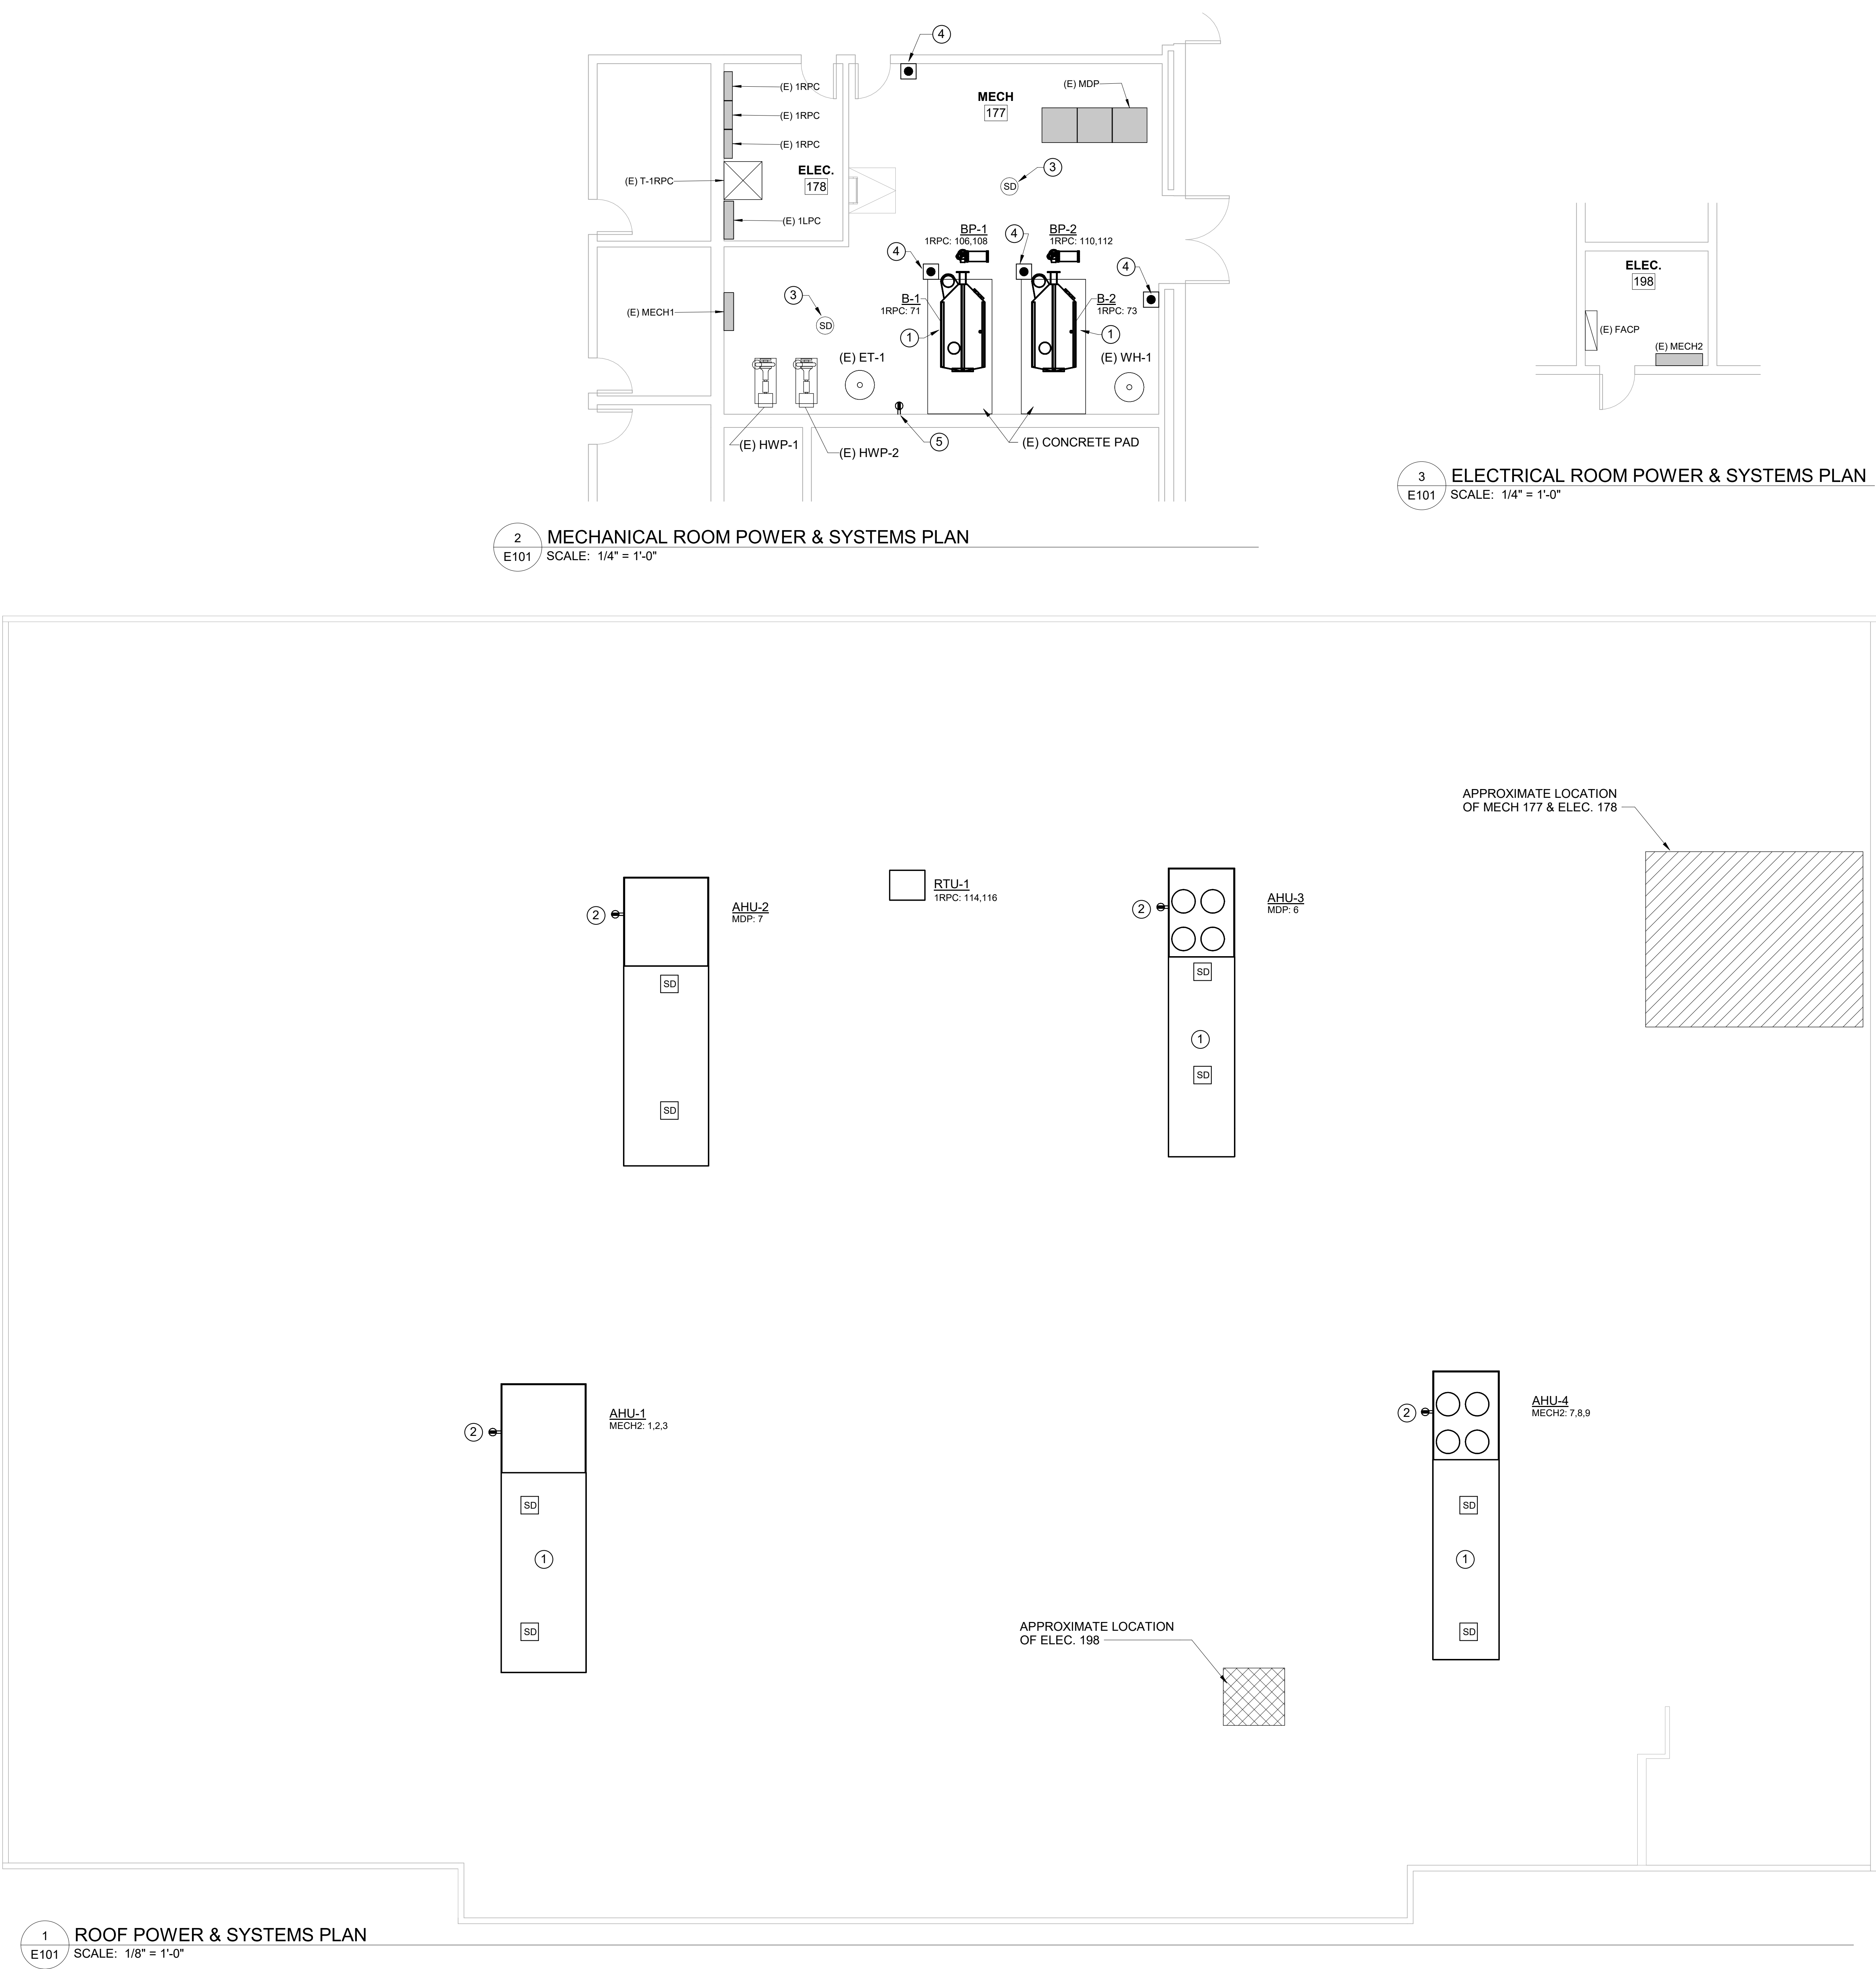

RENOVATION KEYNOTES

- 1 PROVIDE FINAL CONNECTION TO NEW UNIT. MODIFY AND EXTEND EXISTING WIRE AND CONDUIT AS NECESSARY TO PROVIDE POWER TO NEW UNIT.
- 2 PROVIDE POWER TO NEW RECEPTACLE FROM EXISTING RECEPTACLE CIRCUIT. MODIFY AND EXTEND EXISTING WIRE AND CONDUIT AS NECESSARY TO PROVIDE POWER TO NEW RECEPTACLE.
- 3 REPLACE EXISTING SMOKE DETECTOR IN ROOM WITH DUAL CARBON MONOXIDE / SMOKE DETECTOR CONNECTED INTO EXISTING FIRE ALARM SYSTEM. RE-CERTIFY AT COMPLETION OF MODIFICATIONS.
- 4 PROVIDE EMERGENCY STOP (E-STOP) PUSH BUTTONS AT EACH BOILER AND ADJACENT TO THE MECHANICAL ROOM EGRESS DOORS FOR SHUTOFF OF THE BOILERS.
- 5 EXISTING RECEPTACLE. REPLACE WITH GFCI TO SERVE AS MAINTENANCE POWER FOR HVAC/PLUMBING UNITS.

- 1 REINSTALL AND BOND PREVIOUSLY REMOVED LIGHTNING PROTECTION TO NEW HVAC EQUIPMENT ONCE INSTALLED.
- 2 PRIOR TO ORDERING OR INSTALLING ANY FIRE ALARM EQUIPMENT, VERIFY THE EXISTING FIRE ALARM CONTROL PANEL MANUFACTURER, MODEL, AND SYSTEM CONFIGURATION. PROVIDE NEW DEVICES AND ACCESSORIES THAT ARE COMPATIBLE WITH THE EXISTING FIRE ALARM SYSTEM.

- 1 REINSTALL AND BOND PREVIOUSLY REMOVED LIGHTNING PROTECTION TO NEW HVAC EQUIPMENT ONCE INSTALLED.
- 2 PRIOR TO ORDERING OR INSTALLING ANY FIRE ALARM EQUIPMENT, VERIFY THE EXISTING FIRE ALARM CONTROL PANEL MANUFACTURER, MODEL, AND SYSTEM CONFIGURATION. PROVIDE NEW DEVICES AND ACCESSORIES THAT ARE COMPATIBLE WITH THE EXISTING FIRE ALARM SYSTEM.

DWG

CONSULTING ENGINEERS

EMPLOYEES OWNED

1009 Anna Knapp Blvd., Suite 200

Mt. Pleasant, SC 29464

843-849-1141

SOUTH CAROLINA

DWG, INC.

CONSULTING ENGINEERS

No. 038949

CERTIFICATE OF AUTHORIZATION

SOUTH CAROLINA

REGISTERED PROFESSIONAL

No. 39922

10/19/2026

MAXWELL SIM

CCTC HEALTH SCIENCE HVAC REPLACEMENT

133 S MAIN ST. SUMTER, SC 29150

POWER & SYSTEMS PLANS

#	Description	01/01/01
1	Addendum 1	10/19/26

JOB No.

H59-N395-AT

DATE:

10/19/2026

DRAWN BY:

AMH

CHECKED BY:

MHS

SHEET

NUMBER

E101